

ROOF PLAN

SHEET TITLE


BRELIE GEAR
CORPORATE ROAD
WAUKESHA WI

JOB: 3123
DRAWN: Author
CHECKED: Checker
DATE: 12-10-18


SHEET:
A4.1




APPLICABLE TO ALL PLAN VIEWS

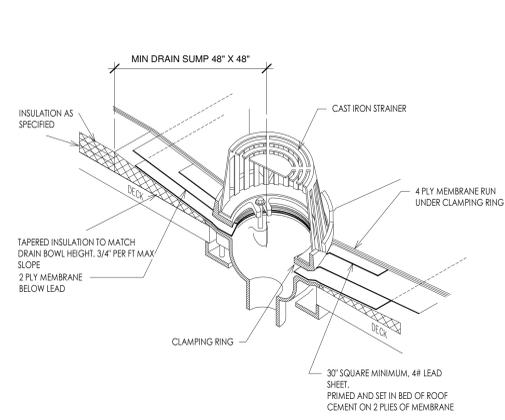


4 ROOF DRAIN DETAIL
1/2\"/>

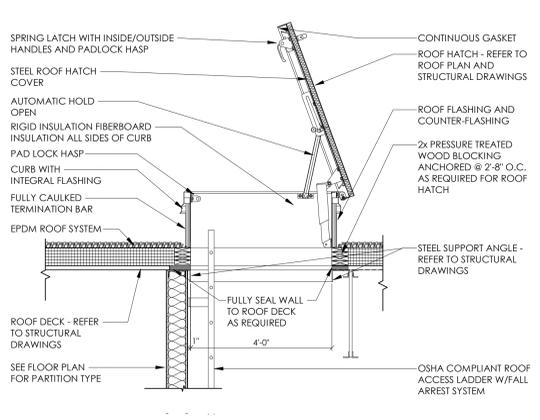


3 ROOF HATCH DETAIL
1/2\"/>

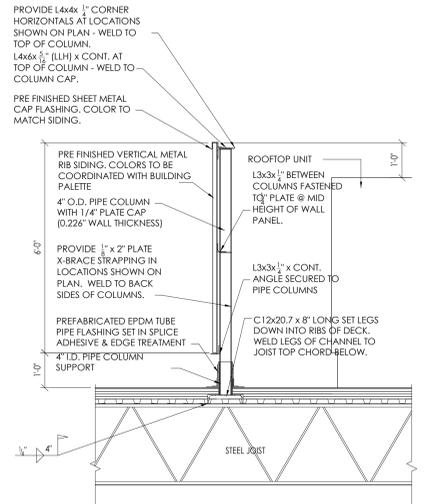

5 ROOF SCREEN SECTION
1/2\"/>

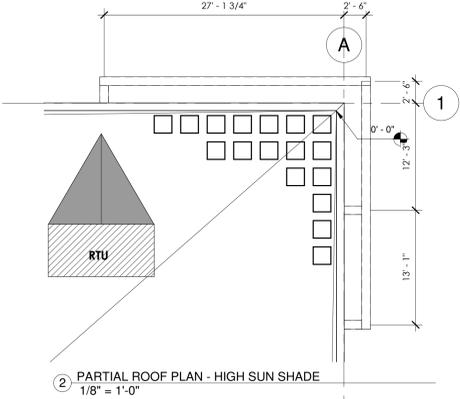

2 PARTIAL ROOF PLAN - HIGH SUN SHADE
1/8\"/>

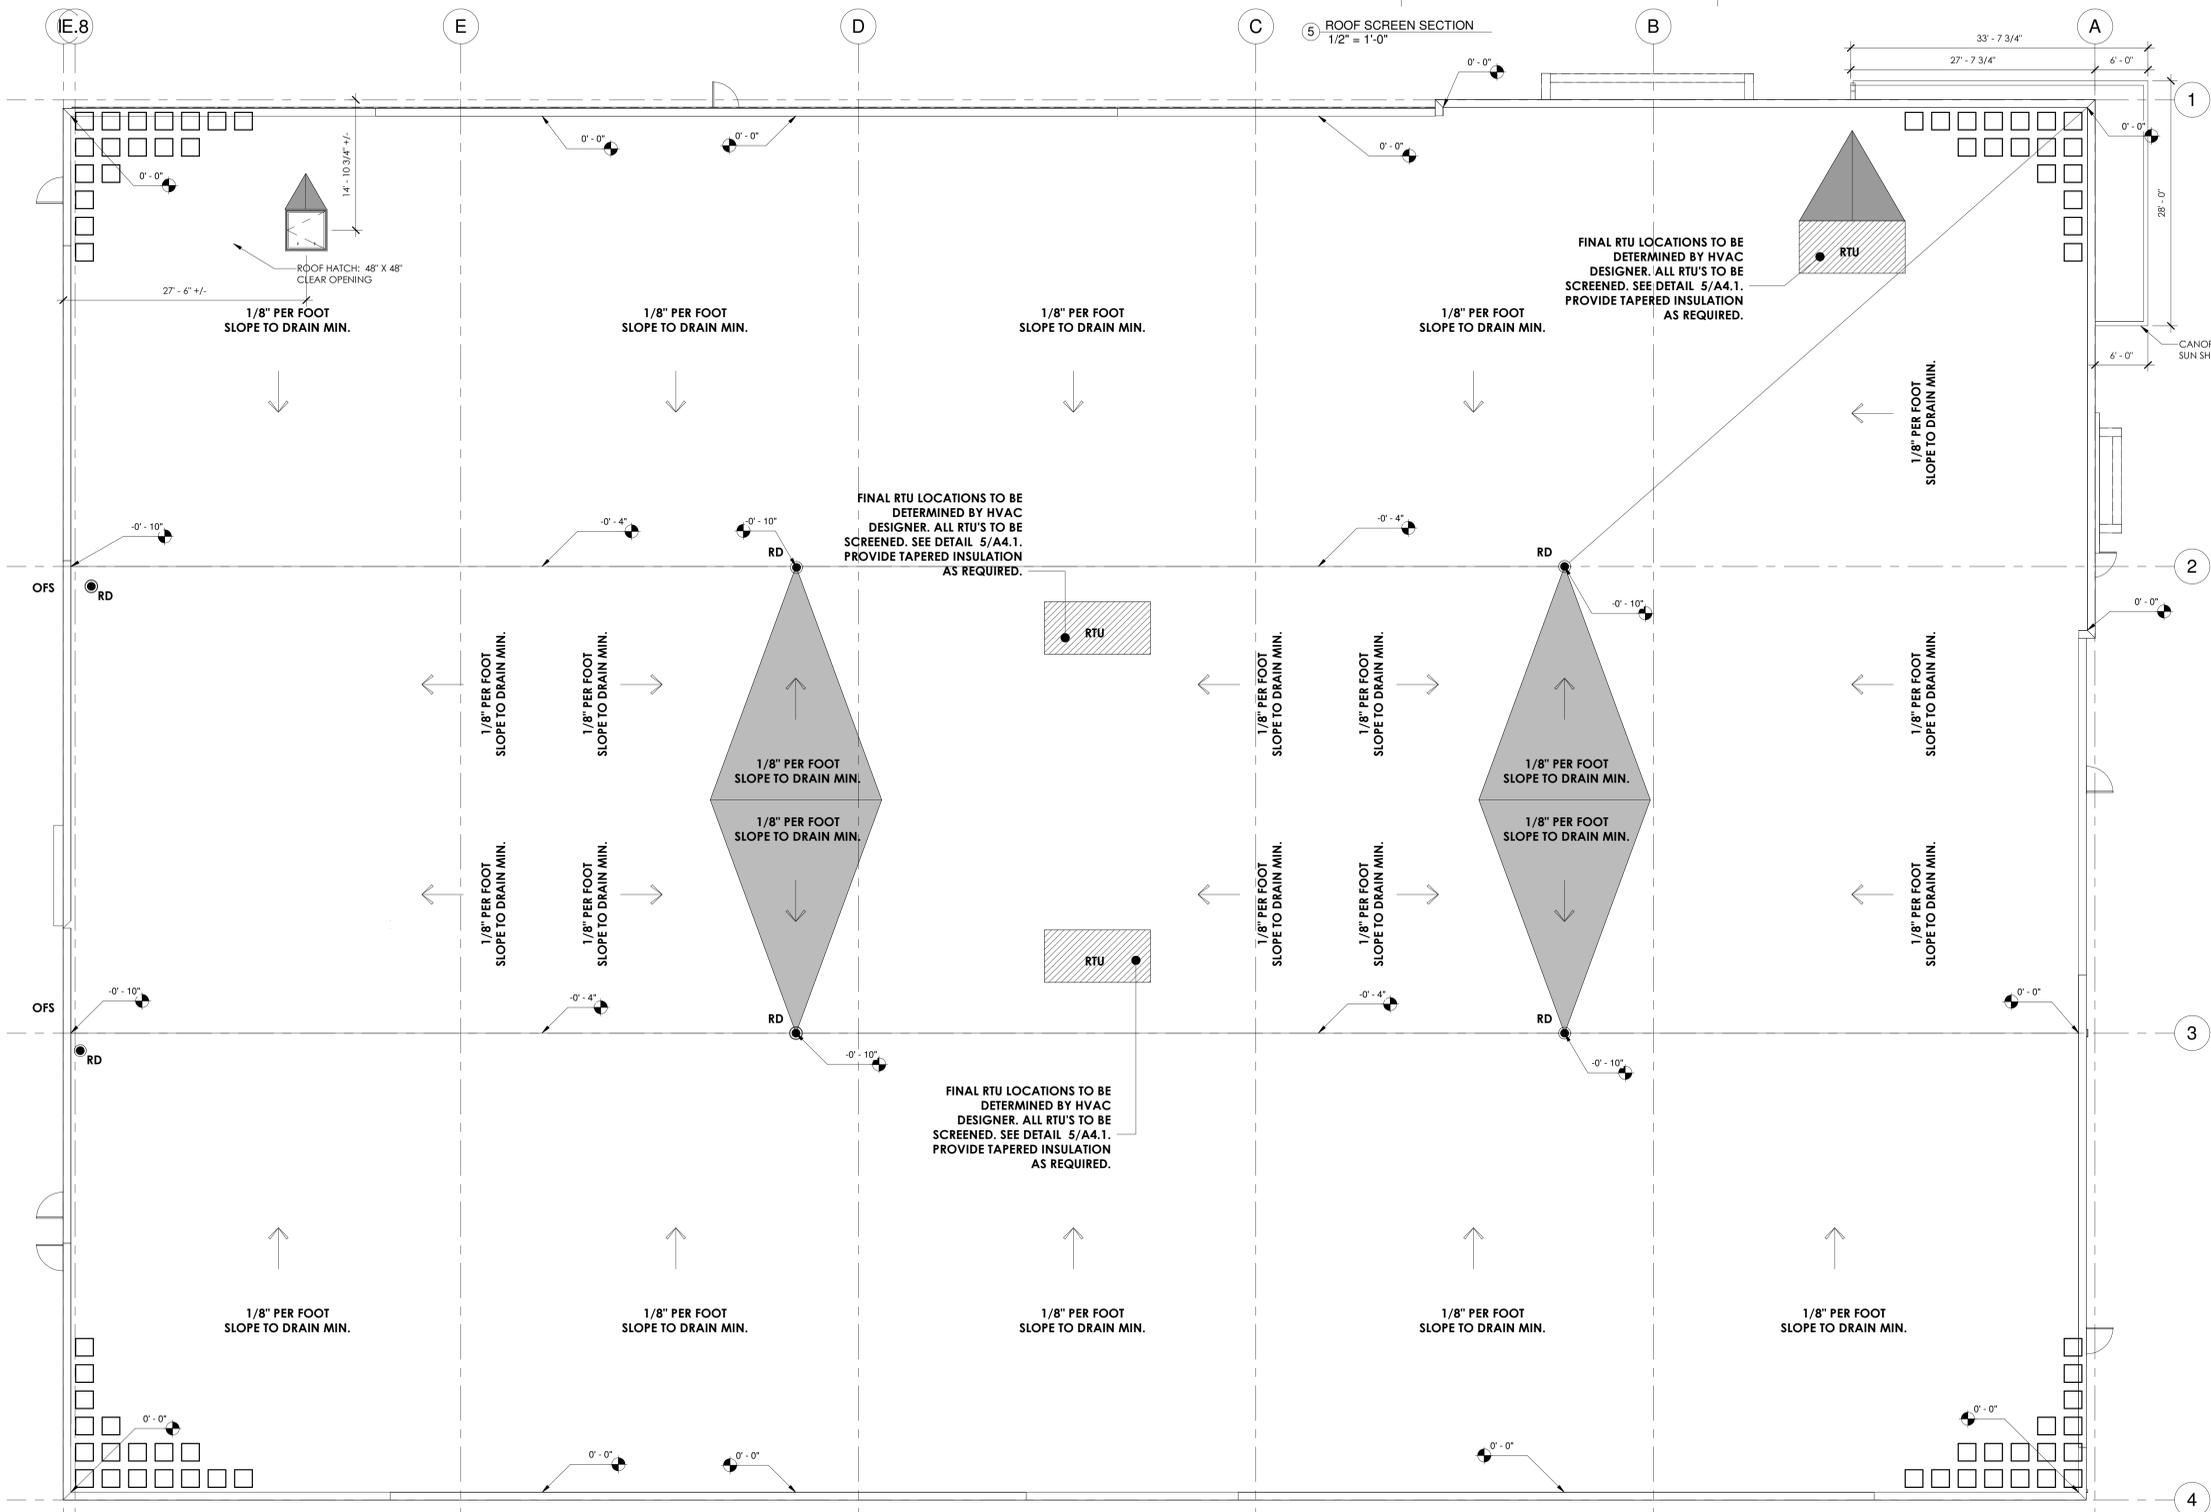

PROVIDE ROOF PAVERS AT ROOF HATCH AND AT ALL ROOF TOP UNITS. REFER TO HVAC PLANS FOR EXACT LOCATION.

1 ROOF PLAN
1/8\"/>