


FOX RUN REDEVELOPMENT

WAUKESHA, WI

JAHNKE & JAHNKE ASSOCIATED, LLC

IN PARTNERSHIP WITH:

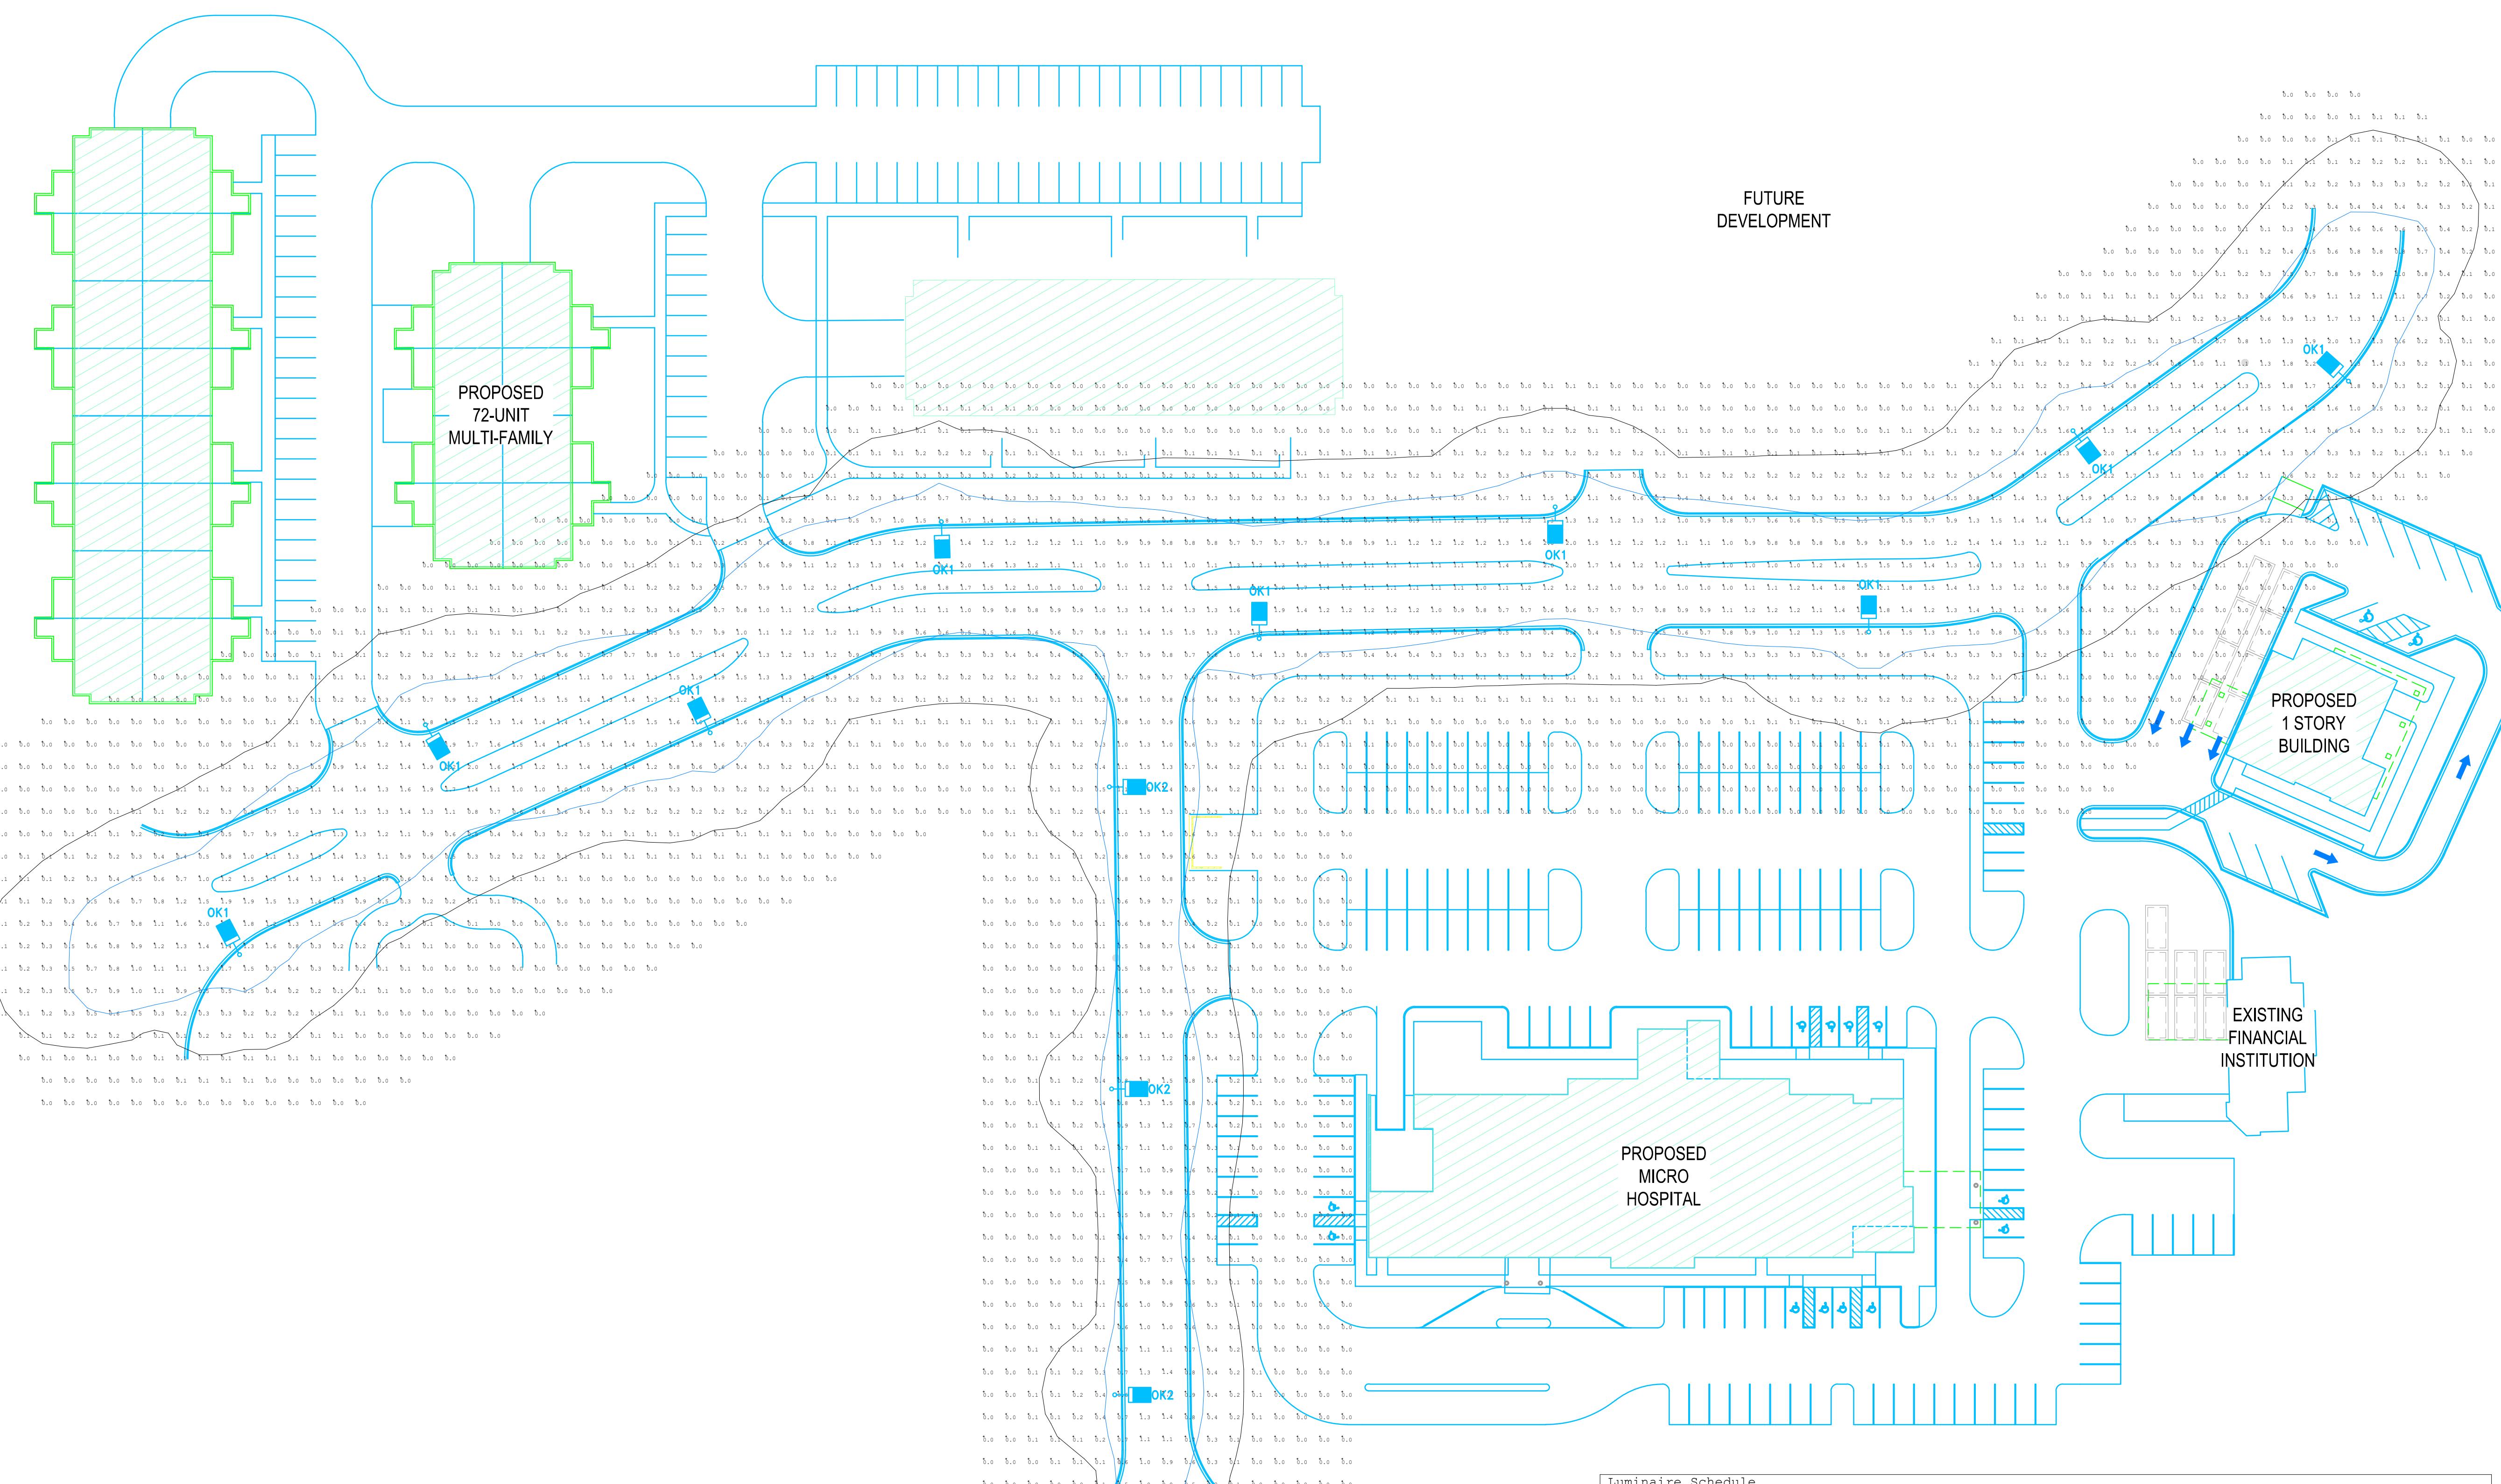

Luminaire Schedule			
Symbol	Oty	Label	Description
■	9	OK1	GLEON-AF-02-LED-E1-T3R-BZ mounted @ 31' above grade on 30' SSS Pole
□	3	OK2	GLEON-AF-01-LED-E1-T2R-BZ mounted @ 31' above grade on 30' SSS Pole

Isoline Legend	
Illuminance (Fc)	Color
0.1	Black
0.5	Blue

RECORDS INFO
DRAWN BY: CRH
DATE: 3/26/20
SCALE: 1"=40'
JOB #: 58608
SHEET DESCRIPTION
SITE
LIGHTING
SHEET NO.

ES01